
## The following the distribution of the following the follow

Elevation South

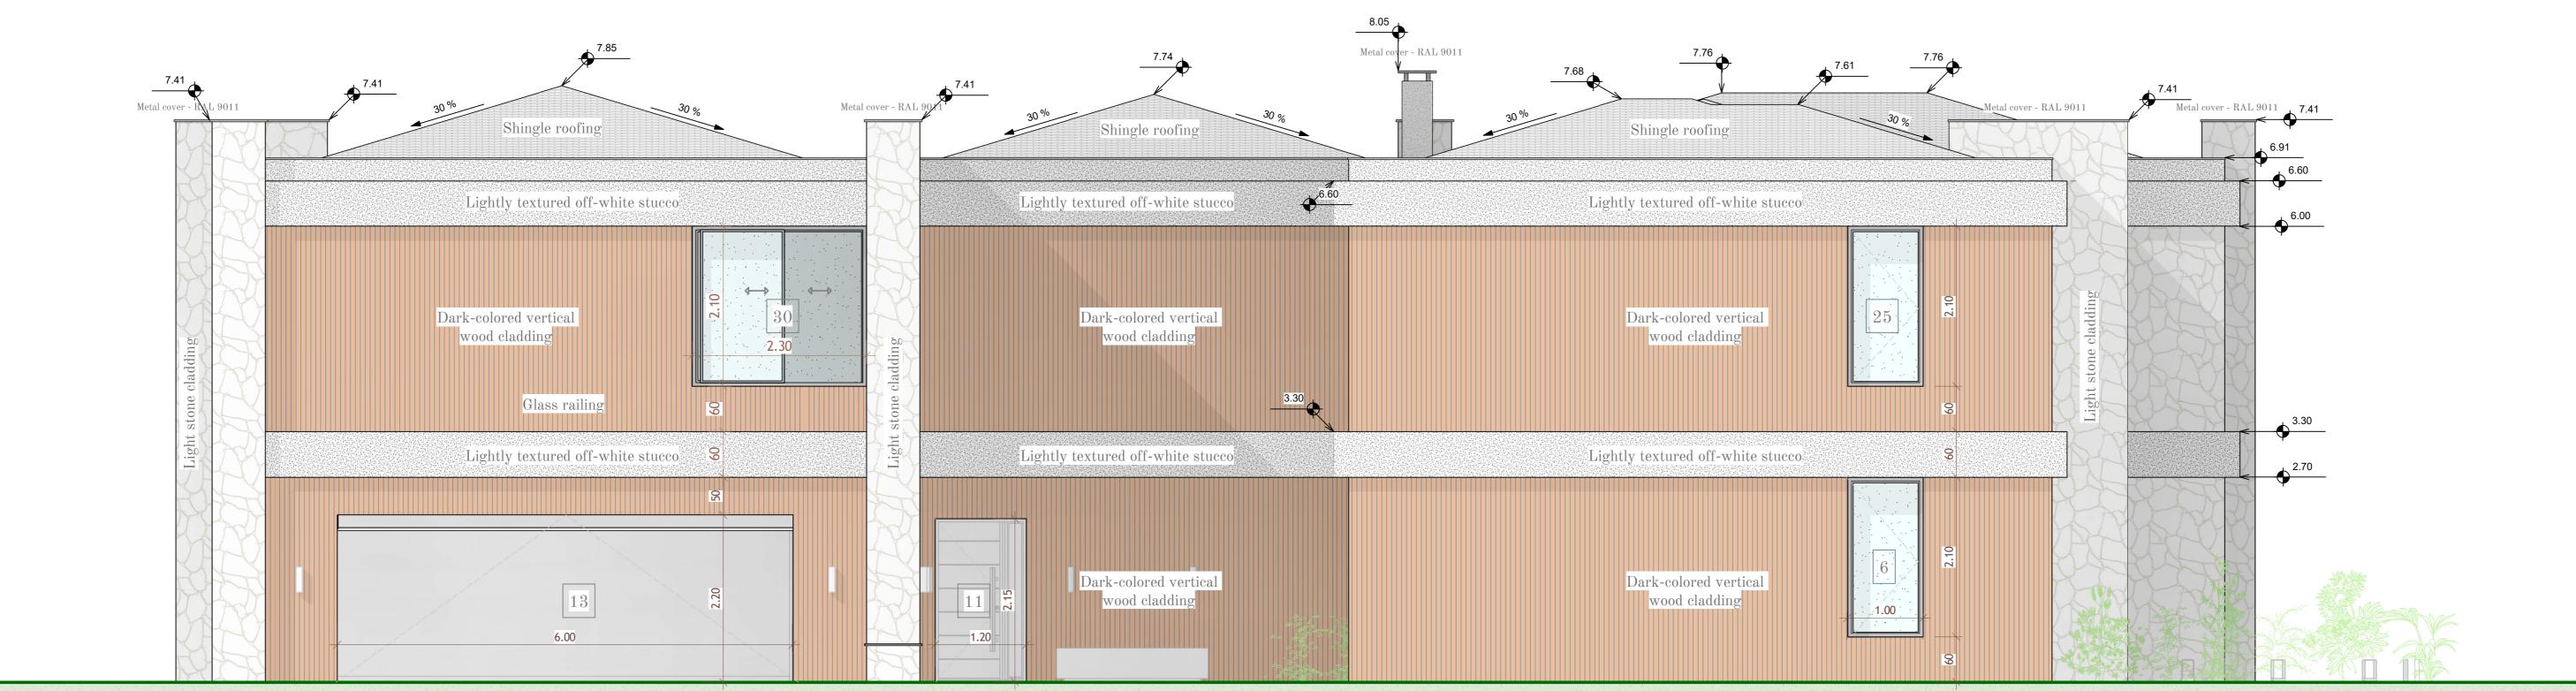

Elevation North

Some jurisdictions require a local architect or engineer to review and adapt the design to comply with local building codes and regulations. We strongly recommend checking with your local building department to confirm the applicable requirements. The sketch phase, preliminary design, and permit drawings cannot be used or applied without confirmation by a structural engineer. We recommend consulting your builder to produce detailed sections at the correct scale for construction, and to the urban planning rules applicable in your municipality.

## CONSTRUTION OF A 7 BEDROOM HOUSE

NAME OF THE BUILDER:

OWNER'S NAME:

001 - LIST OF PAGES

002 - SITE PLAN

003 - SECTION A-A & B-B

004 - SECTION C-C & D-D

005 - SECTION E-E & F-F

006 - SECTION G-G & H-H

007 - SECTION I-I & J-J

008 - SECTION K-K - L-L

009 - SECTION M-M

010 - ELEVATION EAST & WEST

011 - ELEVATION SOUTH & NORTH

012 - FLOOR PLAN - GROUND FLOOR

013 - FLOOR PLAN - FIRST FLOOR

014 - SURFACE PLAN - GROUND FLOOR

015 - SURFACE PLAN - FIRST FLOOR

016 - ELETRIC PLAN - GROUND FLOOR

017 - ELECTRIC PLAN - FIRST FLOOR

018 - PLUMBING PLAN - GROUND FLOOR

019 - PLUMBING PLAN - FIRST FLOOR

020 - FOUNDATION PLAN

021 - SPECIFICATIONS OF WINDOWS

## ELEVATION SOUTH & NORTH

Last name:  First name:		Phone:  Date:		Sheet number
Adress:			elle: 1:40	011